




Revision	Description	Date

SOUTHEAST AREA HIGH SCHOOL
 7900 EAST SHELBY DRIVE
 MEMPHIS, TENNESSEE 38125

ATHLETIC FIELD SPORTS LIGHTING PLAN

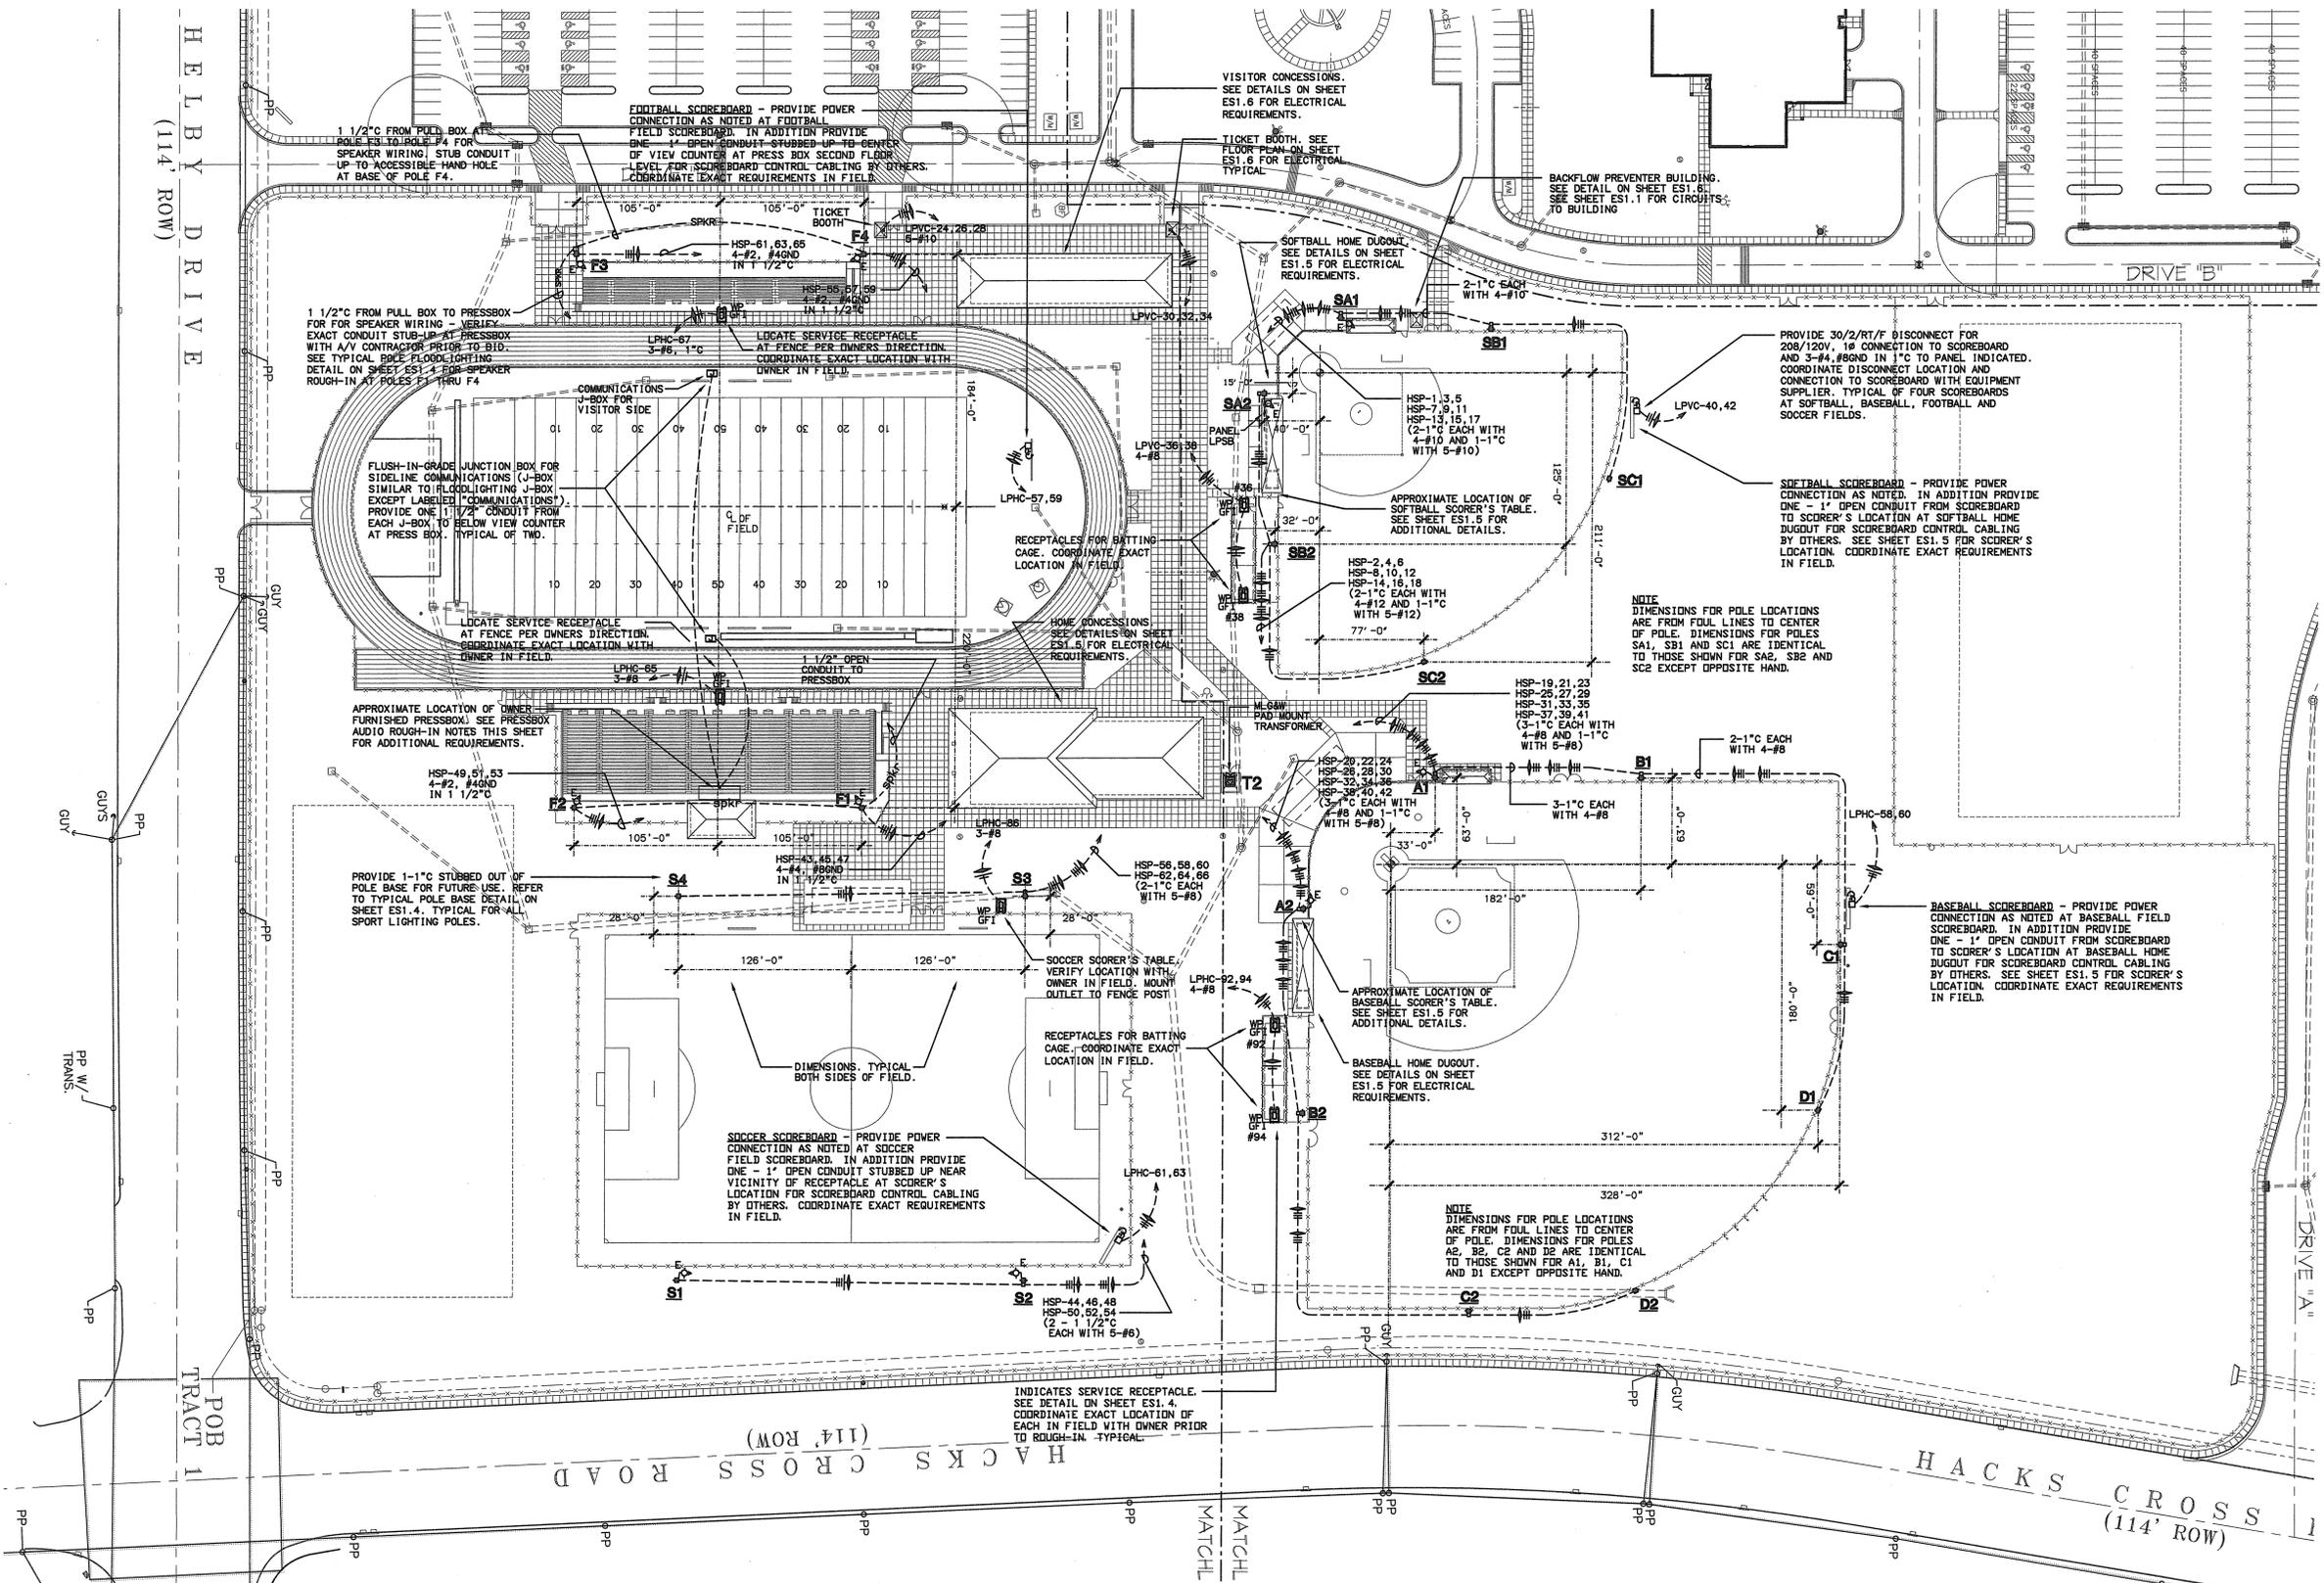

1 SITE PLAN - SPORTS LIGHTING
 1" = 50' - 0"

ROUTE LIGHTING CIRCUITS BEYOND FENCE LIMITS, NOT IN FIELD. TYPICAL ALL FIELDS.

- PRESSBOX AUDIO ROUGH-IN NOTES**
- FURNISH AND INSTALL WALL POCKET "WP37" AT PRESSBOX WHERE DIRECTED BY A/V CONTRACTOR. PROVIDE (1) DUPLEX RECEPTACLE IN WP37 WITH 3-#12 IN 3/4" TO 20/1 CIRCUIT BREAKER IN PANEL LPPR. ALSO, PROVIDE (4) DUPLEX RECEPTACLES AT AUDIO RACK IN PRESSBOX. CONNECT EACH RECEPTACLE TO 20/1 CIRCUIT BREAKER IN PANEL LPPR WITH 3-#12 (4 BRANCH CIRCUITS EACH WITH DEDICATED NEUTRAL). LOCATE RECEPTACLES AT RACK WHERE DIRECTED BY A/V CONTRACTOR. PROVIDE #4 GROUND IN 3/4" FROM AUDIO RACK TO GROUND BUS IN PANEL LPPR.
 - REFER TO TECHNICAL SHEETS FOR ADDITIONAL CONDUIT ROUGH-IN REQUIREMENTS NOT SHOWN ON ELECTRICAL PLANS. COORDINATE EXACT REQUIREMENTS WITH A/V CONTRACTOR PRIOR TO BID.

DePouw Engineering, LLC Apr 13, 2006 - 9:28am K:\01-Active\051114-New SE Area SCS NS\SCANS-SP-Sports.dwg